


1 MAIN LEVEL LIGHTING PLAN
1/8" = 1'-0"

LIGHTING FIXTURE SCHEDULE						
Type	Mark	Manufacturer	Model	Lamp	Electrical Data	Description
A		Lithonia Lighting	2SPG-2/32-A12-MVOLT-GEB-DUAL SWITCH+EL	F32T8/LT741	120 V/1-58 VA	2'x4' SPECIFICATION PREMIUM T8 TROFFER 2X4 2 LP T8 REV APEX A12 LENS 1/3 ELEC (EM BALLAST AS REQUIRED)
B	RFL-LP 011	Lithonia Lighting	SP8F-2/32-A12-MVOLT-GEB-EL(AS REQUIRED)	F32T8/LT741	120 V/1-58 VA	SPECIFICATION PREMIUM TROFFER 1 X 4; 2 LAMP T8; PATTERN #12 ACRYLIC PRISMATIC LENS; ELECTRONIC BALLAST; PAINT AFTER FAB REFL. = .934
B1		Lithonia Lighting	EJS-2/32T8-MVOLT-GEB10IS-WGL	F32T8/LT741	120 V/1-58 VA	ABL Recessed 2x4
C		Lithonia Lighting	DMW-2/32	F32T8/LT741	120 V/1-54 VA	10"Wx4'Lx5-5/8"D ENCLOSED AND GASKETED INDUSTRIAL SURFACE MOUNTED WET LOCATION LISTED FIXTURE, ALUMINUM HOUSING, ACRYLIC LENS
EM		Acuity Brands Lighting	LQMSW3G-120/277-	T5	0 V/1-0 VA	ABL Recessed 2x4
SA		Acuity Brands Lighting	WST-50MH-TB-CWI-DC12	50W MH	120 V/1-69 VA	ARCHITECTURAL SCONCE WITH WIDE THROW DISTRIBUTION WITH CLEAR; FLAT GLASS LENS. CLEAR LAMP.
SR		Acuity Brands Lighting	TWI-42TRT-MVOI T-1 PI-DMB	42W CFI	120 V/1-42 VA	10.5"Hx6.75"Wx3-7/8"D RECESSED WALL MOUNTED FLUORESCENT WALL PACK

LINCOLN PARK LOCKER RENOVATION & ADDITION

SCD Project No : 1033 1

LIGHTING

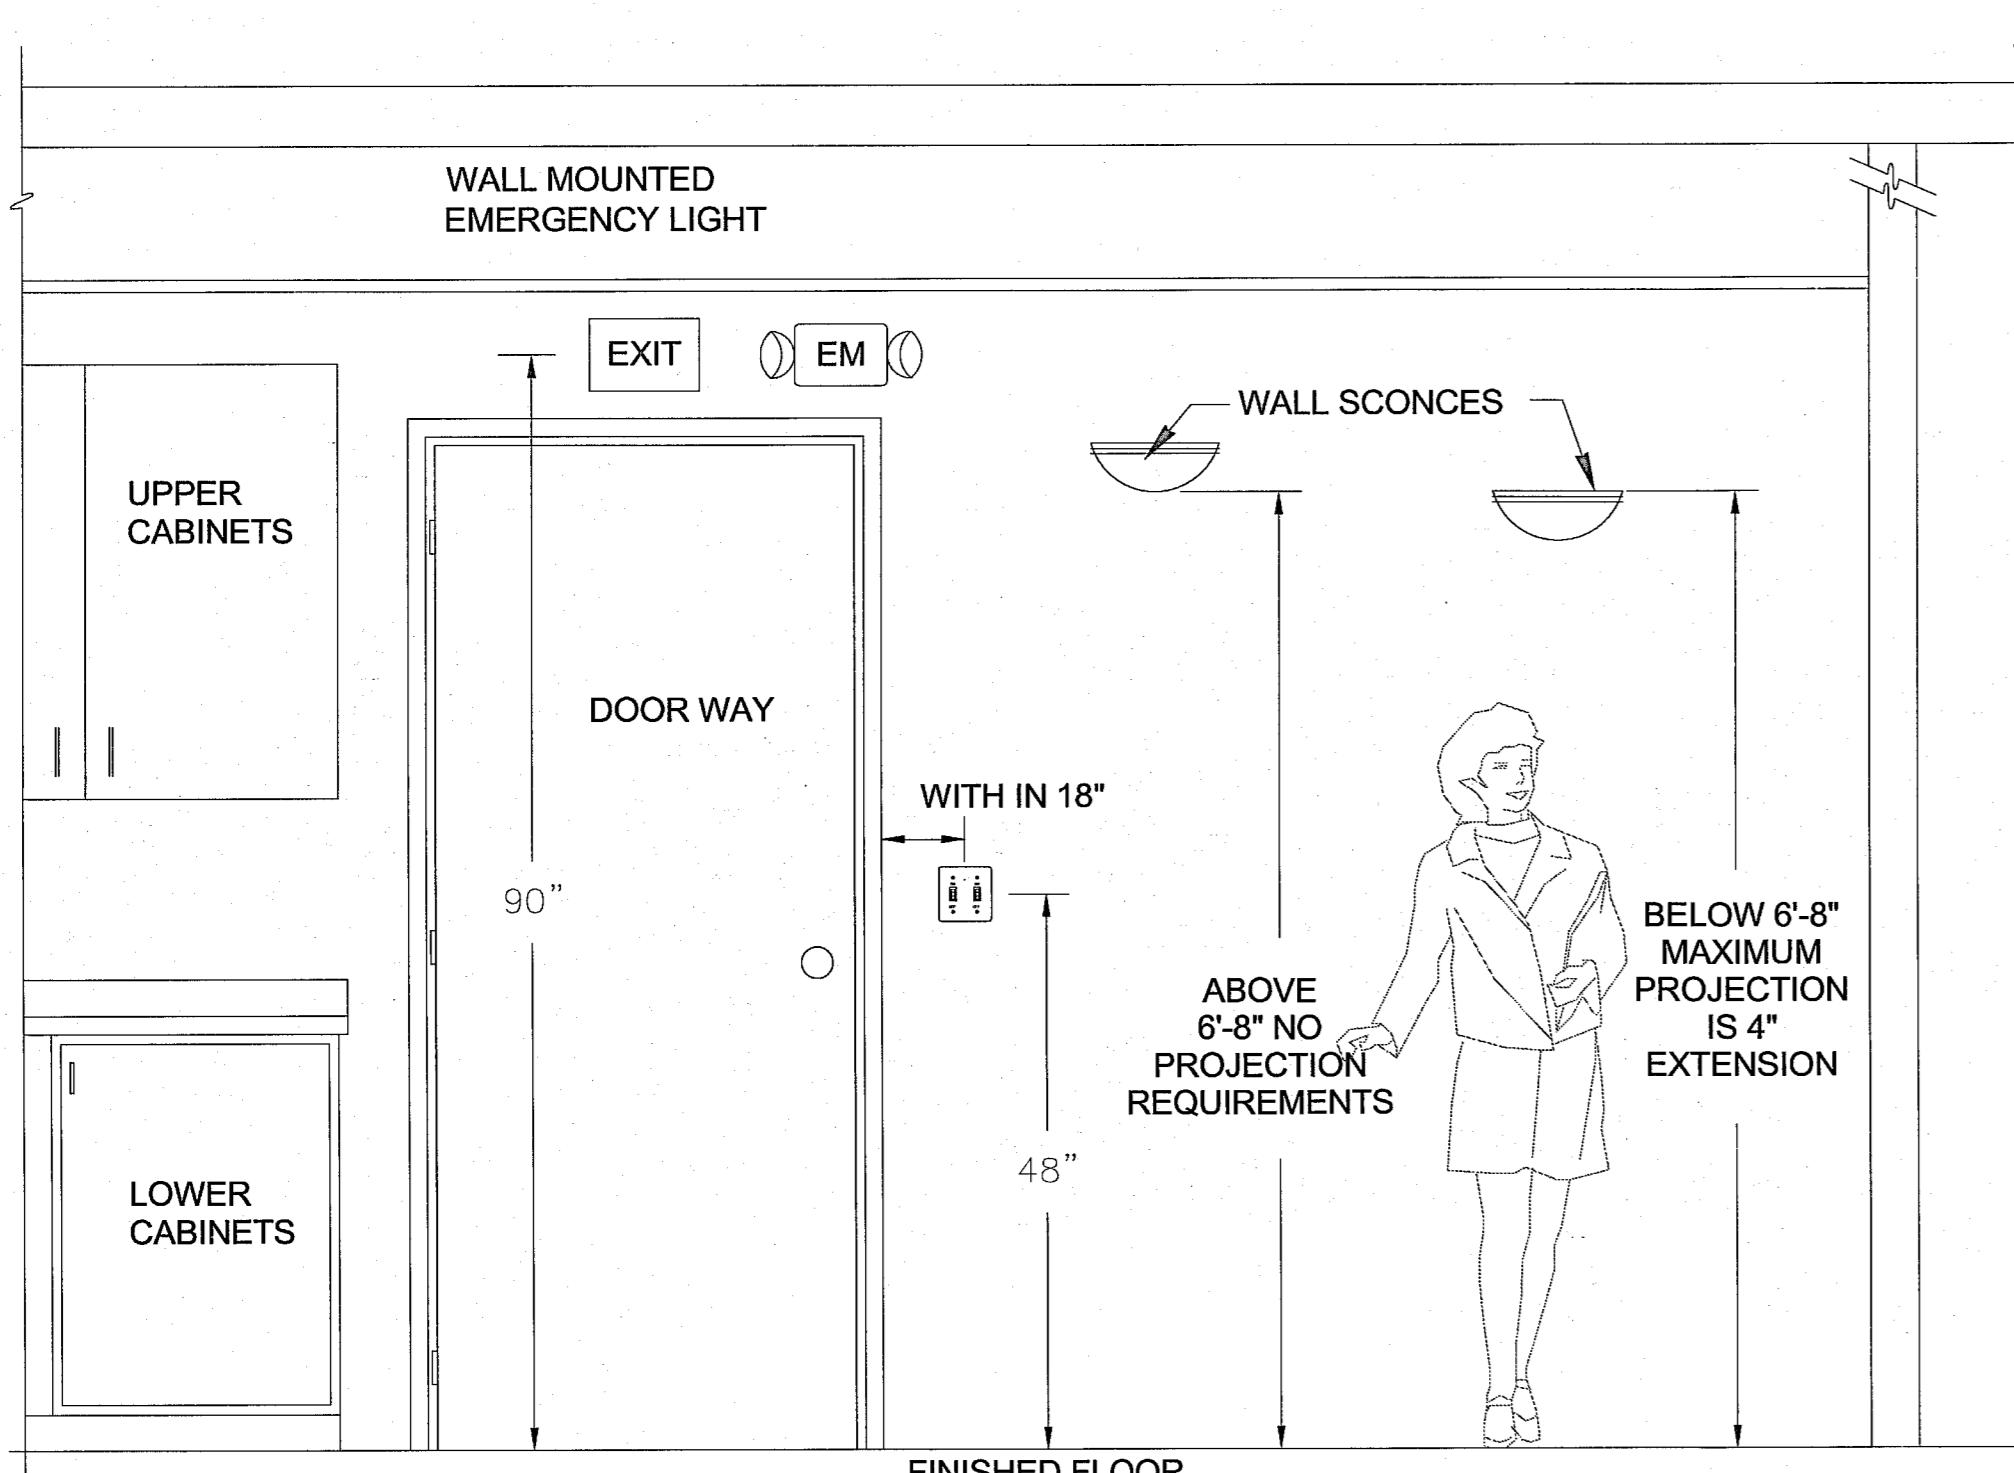


DETAIL NOTES:

1. ALL DEVICES SHOWN ON THIS DETAIL ARE FOR REFERENCES OF MOUNTING HEIGHTS ONLY. THE ELECTRICAL CONTRACTOR SHALL FIELD ADJUST THE HEIGHTS AND LOCATIONS OF THE DEVICES AS REQUIRED FOR PROPER MOUNTING.
2. ALL DEVICES REQUIRED FOR THIS PROJECT MAY NOT APPEAR ON THIS DETAIL. ALL ITEMS SHOWN ON THIS DETAIL MAY NOT BE REQUIRED FOR THIS PROJECT.
3. THE AMERICANS WITH DISABILITIES ACT, KNOWN AS ADA, AFFECTS LIGHT FIXTURES USED IN CIRCULATION EGRESS SPACES. IN PRACTICE THIS MEANS THAT WALL MOUNTED FIXTURES LOCATED BELOW 6'-8" AFF IN HALLS, CORRIDORS, PASSAGEWAYS OR AISLES, MUST BE NO GREATER THAN 4" DEEP. THE ADA AFFECTS CONSTRUCTION FOR BOTH NEW AND EXISTING BUILDINGS.


LIGHTING DEVICE MOUNTING HEIGHT DETAIL

NOT TO SCALE

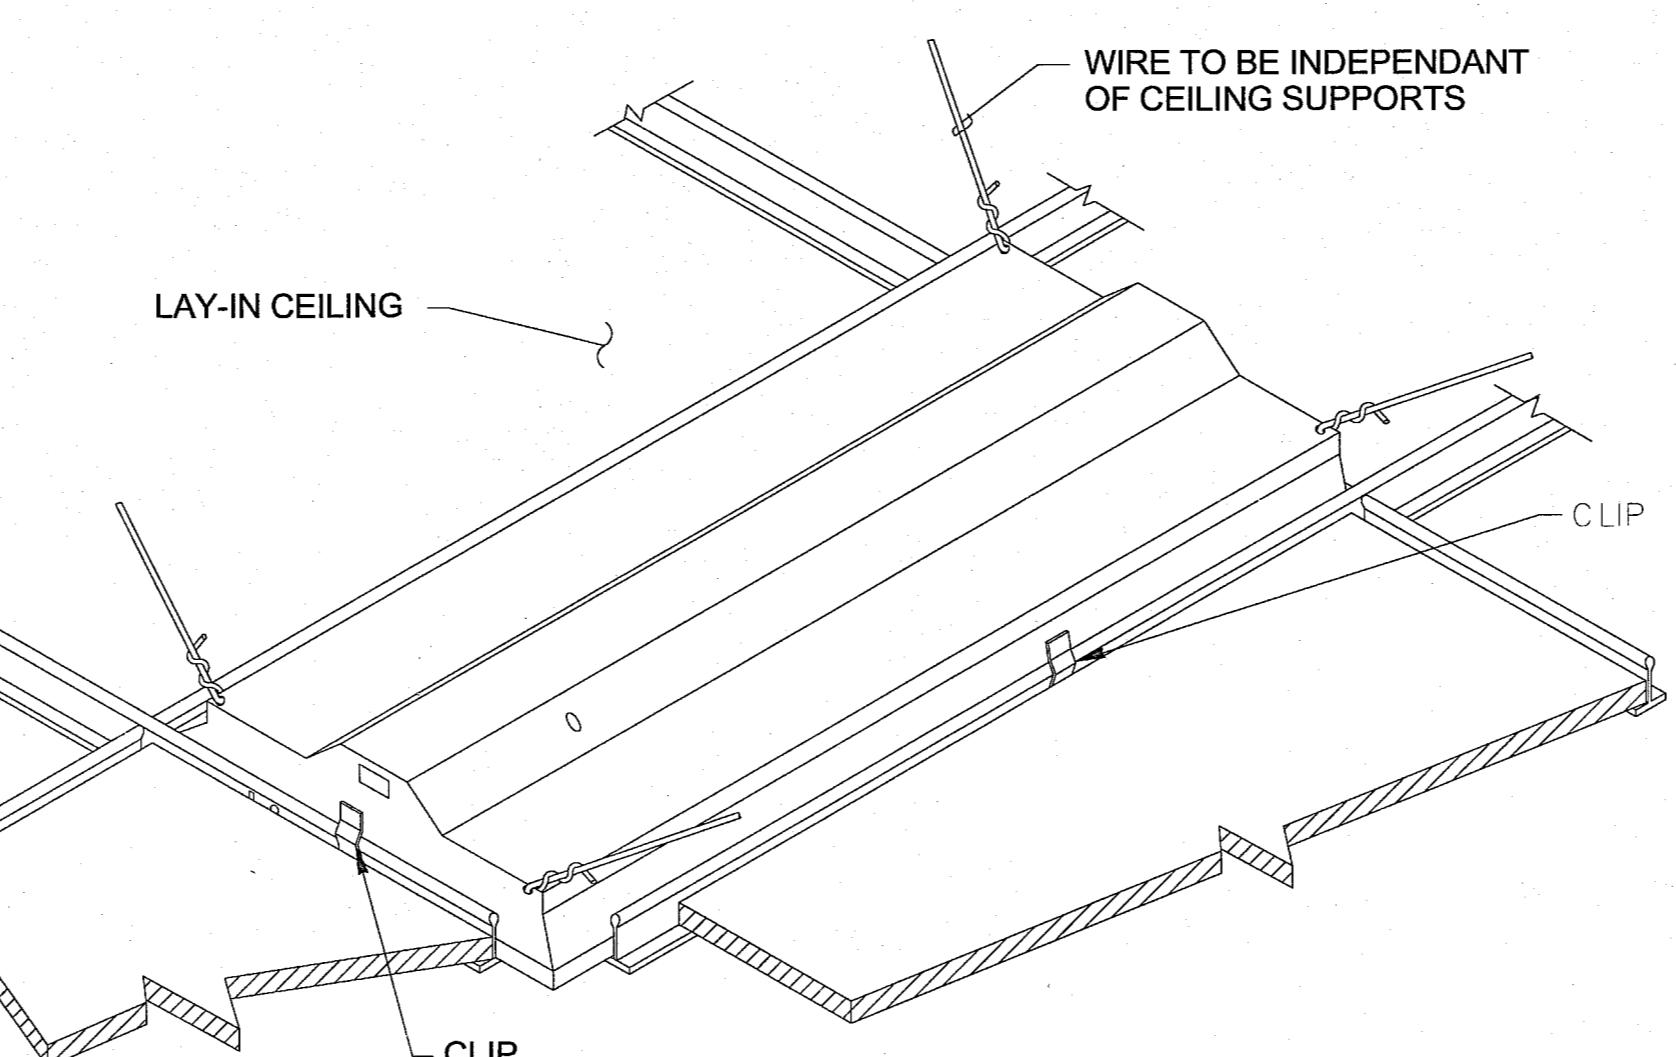

TYPICAL RECESSED LIGHT FIXTURE DETAIL

NOT TO SCALE

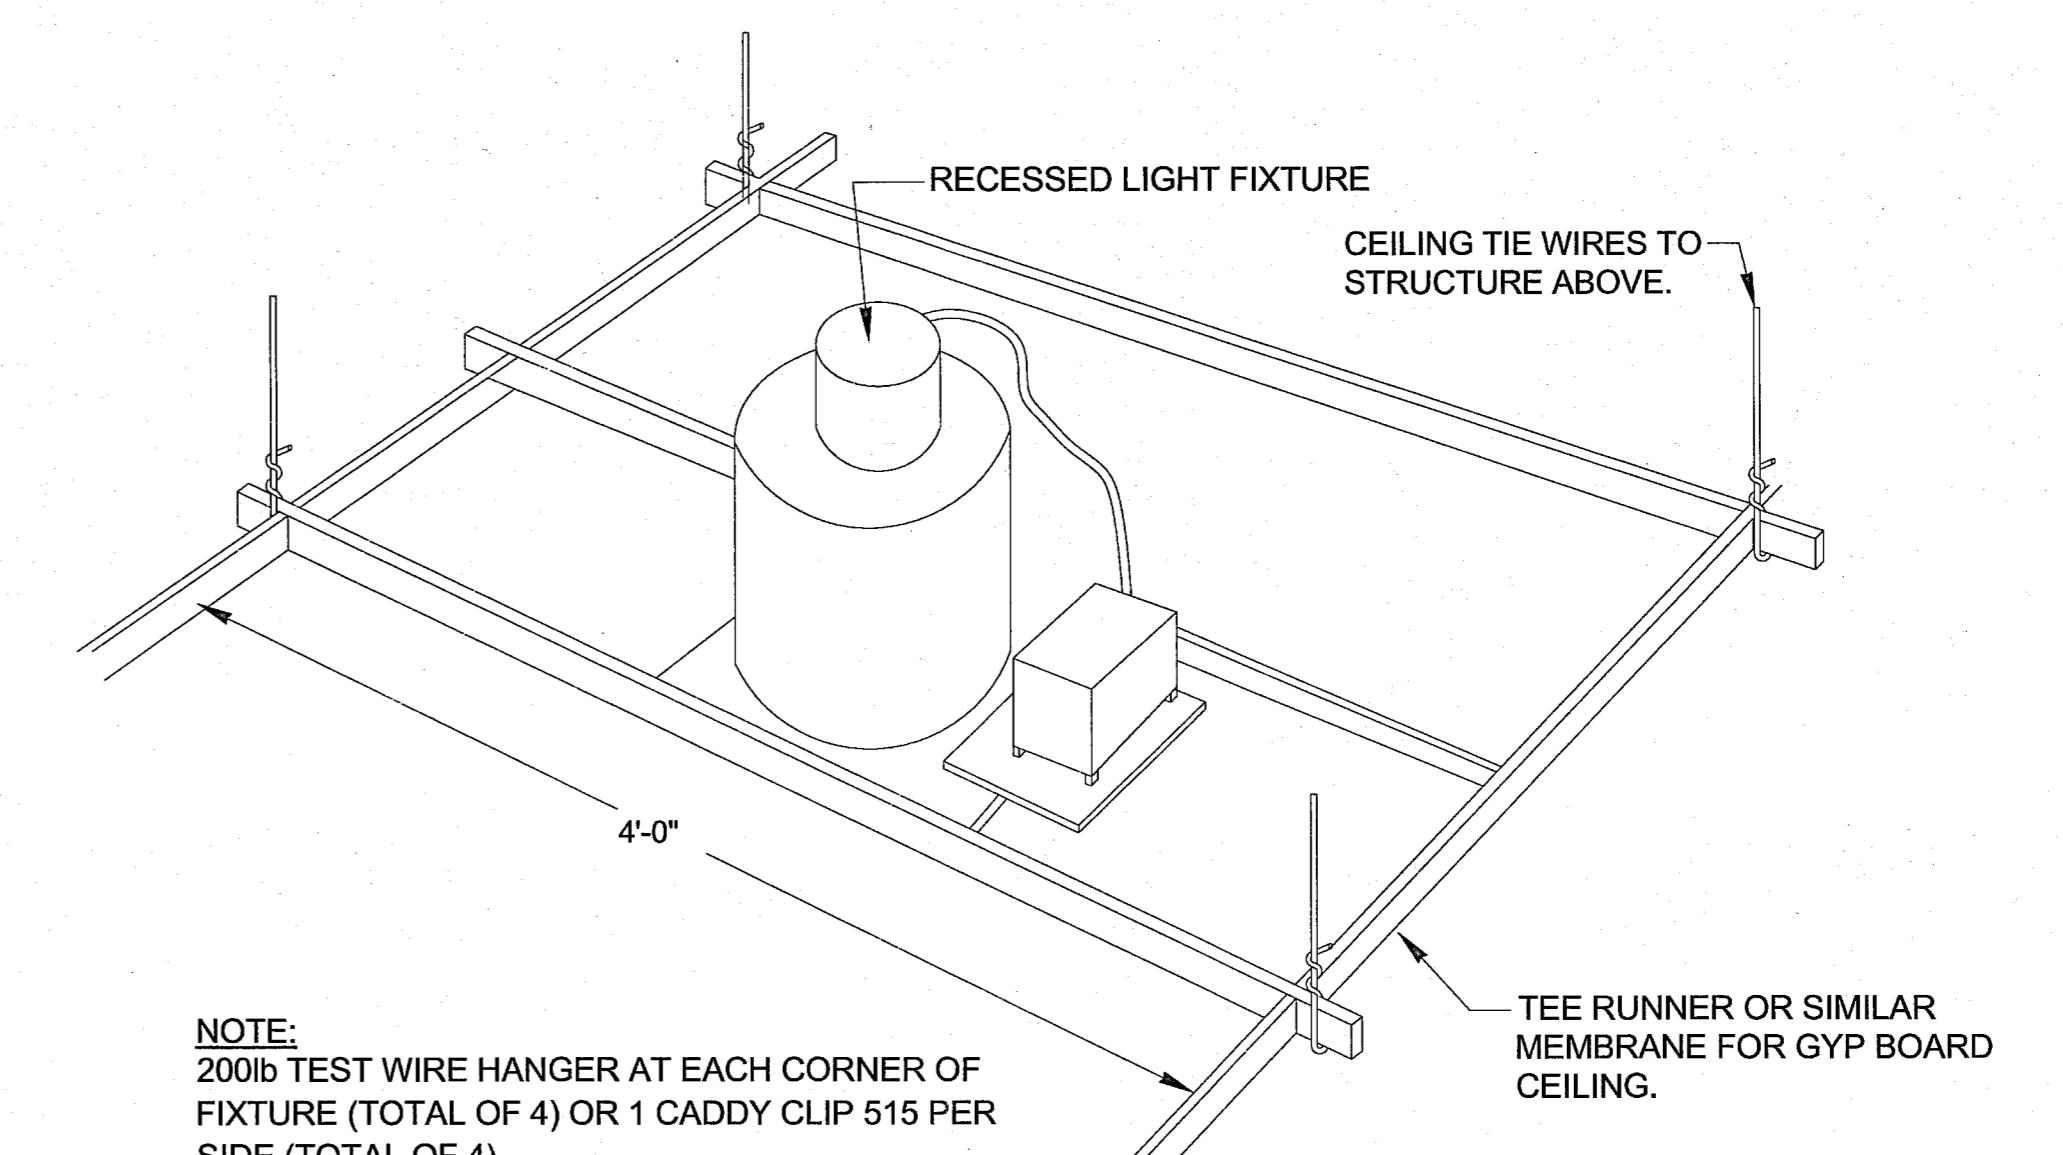

RECESSED LIGHT FIXTURE DETAIL

NOT TO SCALE